



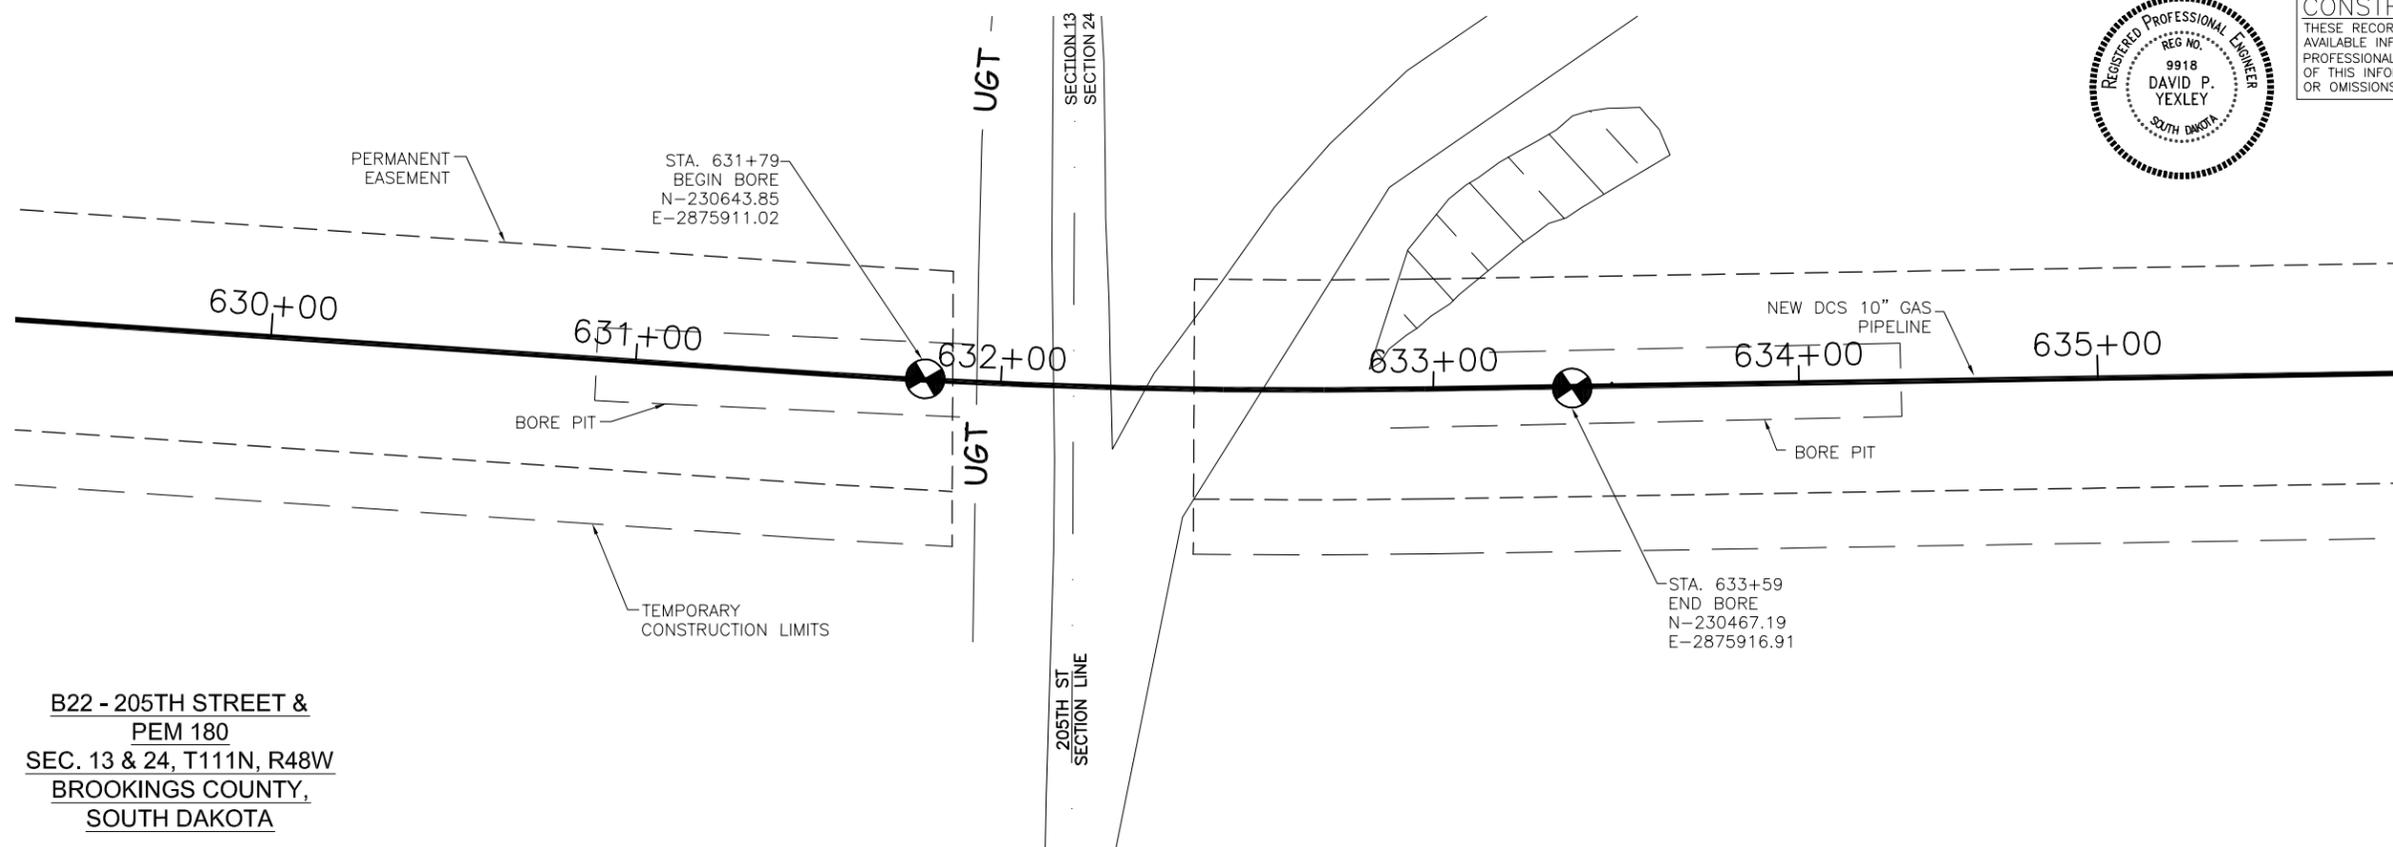

CONSTRUCTION PLANS OF RECORD
 THESE RECORD DOCUMENTS HAVE BEEN PREPARED BASED ON THE BEST AVAILABLE INFORMATION PROVIDED BY OTHERS. THE DESIGN PROFESSIONAL HAS NOT VERIFIED THE ACCURACY AND/OR COMPLETENESS OF THIS INFORMATION AND SHALL NOT BE RESPONSIBLE FOR ANY ERRORS OR OMISSIONS WHICH MAY BE INCORPORATED HEREIN AS A RESULT.

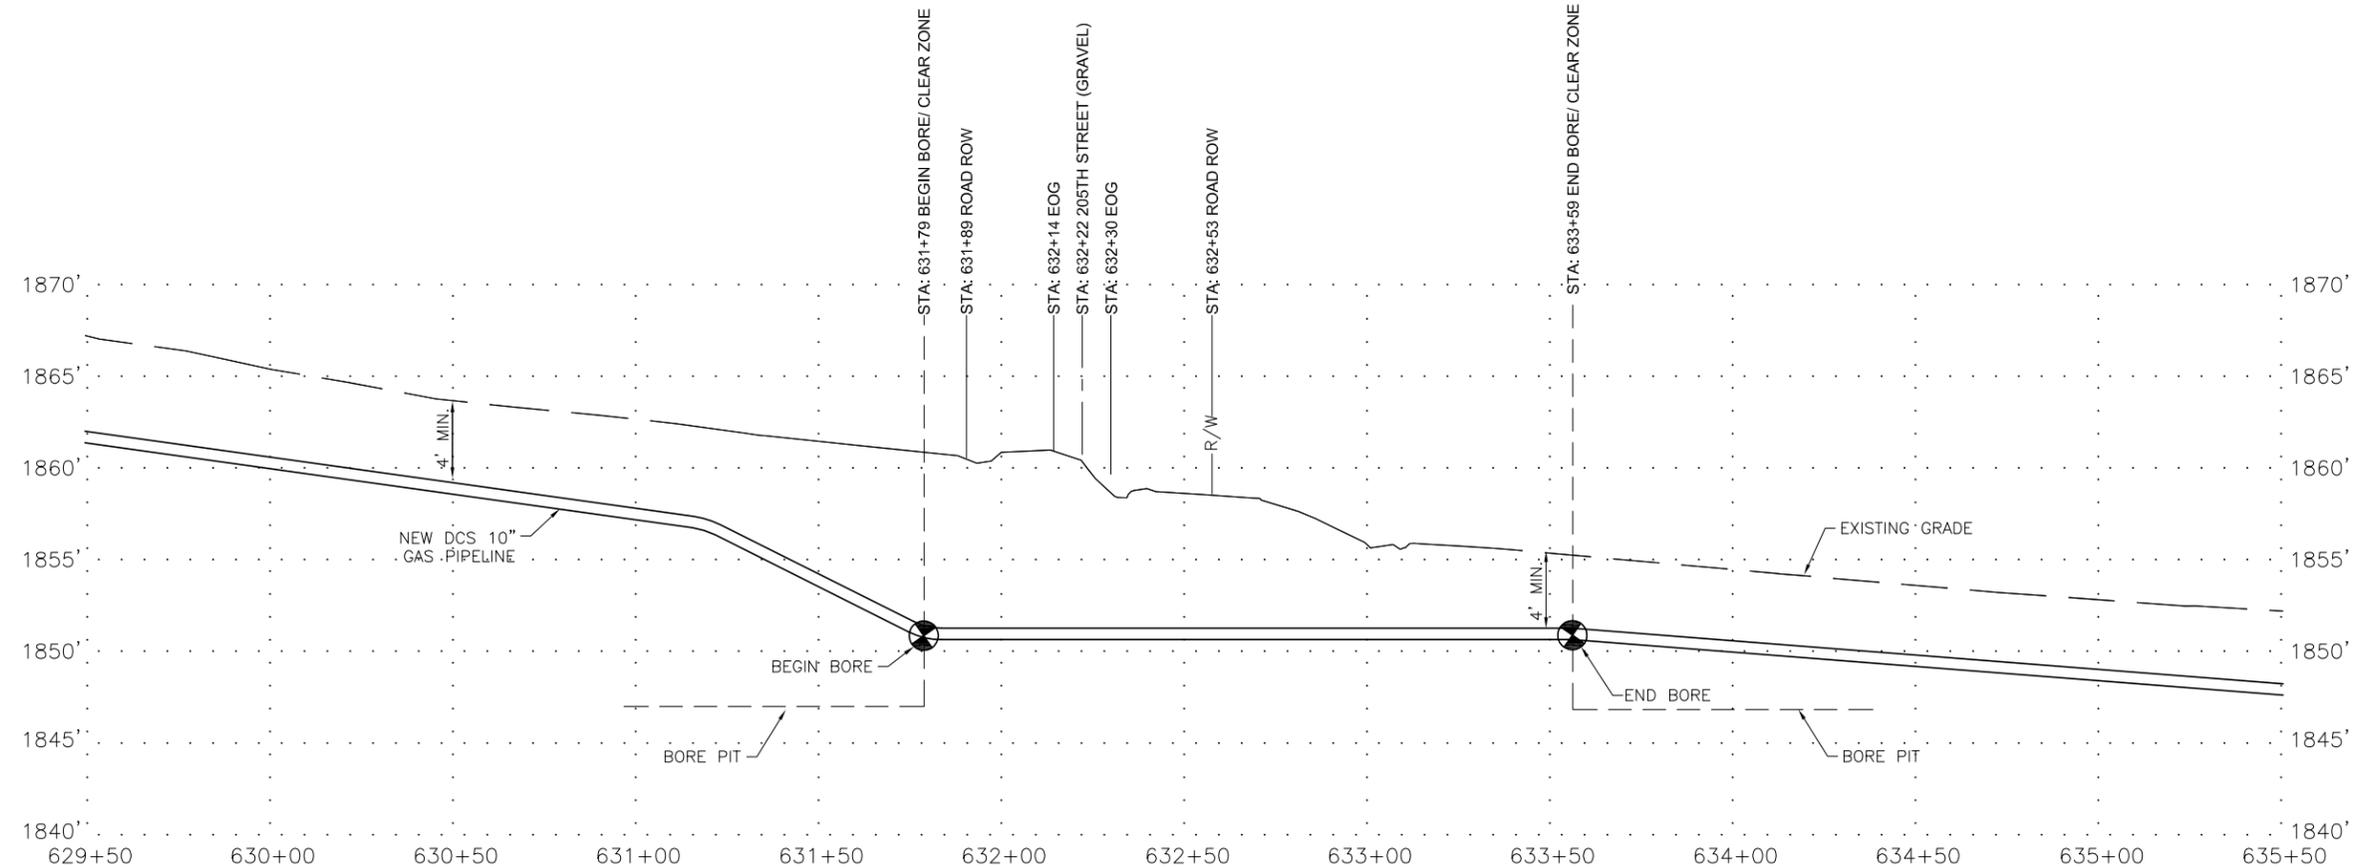

B22 - 205TH STREET & PEM 180
 SEC. 13 & 24, T111N, R48W
 BROOKINGS COUNTY,
 SOUTH DAKOTA

 


NOTE:
 BEARINGS AND DISTANCES ARE BASED ON THE SOUTH DAKOTA STATE PLANE COORDINATE SYSTEM, NORTH ZONE - NAD83 (US SURVEY FEET)

LAND DIMENSION INFORMATION FOR THIS EXHIBIT WAS DERIVED FROM LAND SURVEY DATA.

ALL UNDERGROUND UTILITIES ARE SHOWN IN GENERAL LOCATION. CONTRACTOR TO FIELD VERIFY PRIOR TO CONSTRUCTION.

SEE PLAN AND PROFILE SHEETS FOR LEGEND.



BANNER
 Engineering | Architecture | Surveying
 409 22nd Avenue S. | PO Box 298
 Brookings, South Dakota 57006
 605.692.6342
 www.bannerassociates.com
 Designing Projects | Building Trust

REVISIONS	
NO.	DATE
1	11/17/10
	UPDATED SHEET TITLE

BASIN ELECTRIC POWER COOPERATIVE
 A Touchstone Energy® Cooperative

MONTANA-DAKOTA UTILITIES CO.
 A Division of MDU Resources Group, Inc.

DEER CREEK STATION GAS PIPELINE
 DEUEL & BROOKINGS COUNTY, SOUTH DAKOTA
 DCS-CD-ONG-0017

DRAWN BY: AME	CHECK BY: SDR
SIGNED BY: DPY	ENGINEER
DATE: JANUARY 2011	
GAS PIPELINE BORING - B22 AT 205TH STREET	
DCS-B17	